

| | |
|------------|-----|
| REVISIONS: | BY: |
| | |
| | |
| | |
| | |
| | |
| | |
| | |
| | |


WARMBOARD, INC.
 100 ENTERPRISE WAY, SUITE G300
 SCOTT'S VALLEY, CALIFORNIA 95066
 1.800.556.0595
 WARMBOARD.COM




BISHOPOGATE ST.
 JOB# 60360
 MOUNT GAMBIER, ASTL

**PANEL-TUBE
 LAYOUT**

DATE: 9/27/2021
 SCALE: 1/4" = 1'
 DRAWN: J. Latanne
 REVIEWED: TW
 SHEET:
 1 OF 2

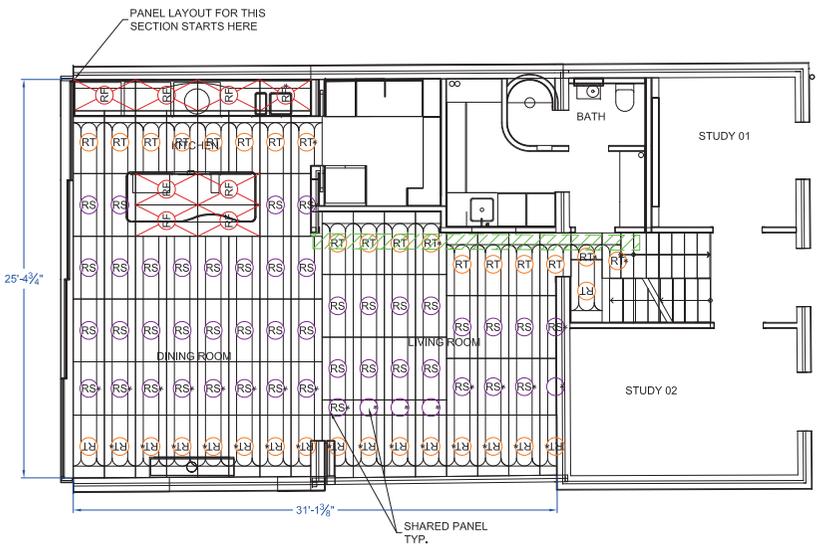

GROUND FLOOR PANEL LAYOUT
 Scale: 1/4"=1'-0"

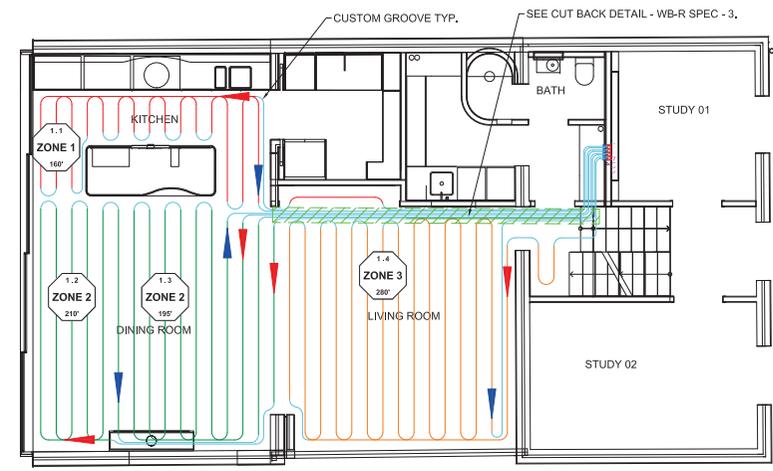

GROUND FLOOR TUBE LAYOUT
 Scale: 1/4"=1'-0"

MANDATORY STRUCTURAL NOTES

- TO ENSURE OPTIMAL PANEL INSTALLATION, FOLLOW PANEL LAYOUT PLANS. ALL WARMBOARD INSTALLATION INSTRUCTIONS, AND APA GUIDELINES. FAILURE TO DO SO COULD CAUSE PANEL WASTE.
- WARMBOARD PLANS ARE CONCEPTUAL AND DO NOT SUPERSEDE STRUCTURAL PLANS WHICH MAY BE PART OF THE ARCHITECTURAL PLAN SET. SHOULD THERE BE A CONFLICT BETWEEN WARMBOARD PLANS AND THE STRUCTURAL PLANS, CONSULT IMMEDIATELY WITH WARMBOARD CUSTOMER SERVICE BEFORE PROCEEDING.
- INSTALLING CONTRACTOR IS RESPONSIBLE TO VERIFYING ALL MEASUREMENTS PRIOR TO THE INSTALLATION OF WARMBOARD PANELS.

QUESTIONS? FOR IMMEDIATE ASSISTANCE
 CALL: 877-338-5493 (8AM - 5PM PT)

IMPORTANT:
 RETAIN ALL OFF CUTS TO FILL IN SECTIONS AS NEEDED.

| PANEL SCHEDULE | | |
|----------------|----------|----------|
| TYPE | QUANTITY | COMMENTS |
| RS | 44 | (1) |
| RT | 35 | (1) |
| RF | 8 | (2) |

(1) ANY PANELS IN THE DRAWING THAT ARE MARKED WITH AN asterisk (*) INDICATE A PANEL THAT IS TO BE TRIMMED. A CAREFUL MEASUREMENT SHOULD BE MADE TO GUARANTEE A CORRECT INSTALLATION.

(2) OSB PLYWOOD PANELS USED TO FILL IN EMPTY SPACES WHERE WB-REMODEL PANEL MAY NOT BE APPROPRIATE.

WARMBOARD LEGEND

| | |
|-----------------------------|-----------------|
| (RS) REMODEL STRAIGHT PANEL | — TUBING |
| (RT) REMODEL TURN PANEL | — CUSTOM GROOVE |
| (RF) REMODEL FILLER PANEL | — BURIED TUBING |
| * DENOTES TRIMMED PANEL. | • BURIED POINT |

IMPORTANT NOTE:
 INSULATING JOIST CAVITIES BELOW EXISTING SUBFLOOR IS REQUIRED.

| ESTIMATED CUSTOM ROUTES | |
|--|------|
| TURNS | 59 |
| TOTAL LINEAR LENGTH OF STRAIGHT ROUTES | 189' |

| LOOP SCHEDULE | | | |
|---------------|----------|------|---------|
| ZONE | MANIFOLD | LOOP | LENGTH |
| 1 | 1 | 1 | 160' |
| 2 | 1 | 2 | 210' |
| 2 | 1 | 3 | 195' |
| 3 | 1 | 4 | 280' |
| Total | | | 845'-0" |

MANDATORY TUBING NOTES

- USE ONLY WARMBOARD APPROVED TUBING. SEE INSTALLATION MANUAL
- USE AN APPROPRIATELY WEIGHTED ROLLER TO PRESS TUBING INTO CHANNELS.
- MINOR FIELD MODIFICATION OF TUBING PLAN IS WELCOME AND TYPICAL, WHEN IN DOUBT CALL WARMBOARD CUSTOMER SERVICE.

QUESTIONS? FOR IMMEDIATE ASSISTANCE
 CALL: 877-338-5493 (8AM - 5PM PT)